

Alterations for: Train Depot

Forest Ave and Brooke Street
Fond du Lac, WI 54935



**Architects in
Common LLC**
N9224 Mengel Hill Road
Fond du Lac, WI 54937
920.933.2611
www.architectsincommon.com

© Copyright 2024
This document, or any portion thereof, shall not be
duplicated, disclosed, or used on any other project
or extension of this project except by written
agreement with Architects in Common, LLC (AIC).
AIC shall not be responsible for any unauthorized
use of, or alteration to these documents.



PROJECT LOCATION

NORTH
SITE LOCATION MAP

CONSULTANTS

FIRE PROTECTION
FOX VALLEY MEP
6264 BLACK WOLF POINT ROAD
OSHKOSH, WI 54902
T 920.370.7070

SHEET INDEX

GENERAL
G0.1 COVER SHEET

ARCHITECTURAL
A2.1 FLOOR PLANS AND EXTERIOR ELEVATIONS

FIRE PROTECTION
F1.0 BASEMENT FIRE PROTECTION PLAN
F1.1 FIRST FLOOR FIRE PROTECTION PLAN

Consultant

General Contractor
Project Status

Issued for
Bid

Issued

Drawn By: tkent
Checked By: tkent

Train Depot
Fond du Lac, WI

Issue Date: 5-20-2024
Sheet Contents
COVER SHEET

Project Designed For:
City of
Fond du Lac

24-005
Project Number

G0.1

Sheet Number
5/21/2024 3:19:46 PM



**Architects in
Common LLC**

N9224 Mengel Hill Road
Fond du Lac, WI 54937
920.933.2611

www.architectsincommon.com

© Copyright 2024
This document, or any portion thereof, shall not be
duplicated, disclosed, or used on any other project
or extension of this project except by written
agreement with Architects in Common, LLC (AIC).
AIC shall not be responsible for any unauthorized
use of, or alteration to these documents.

Consultant

General Contractor
Project Status

**Issued for
Bid**

Issued

Drawn By: tkent

Checked By: tkent

Train Depot
Fond du Lac, WI

Issue Date: 5-20-2024


Sheet Contents
**FLOOR PLANS
AND EXTERIOR
ELEVATIONS**

Project Designed For:
City of
Fond du Lac

24-005
Project Number


A2.1

Sheet Number
5/21/2024 3:19:45 PM

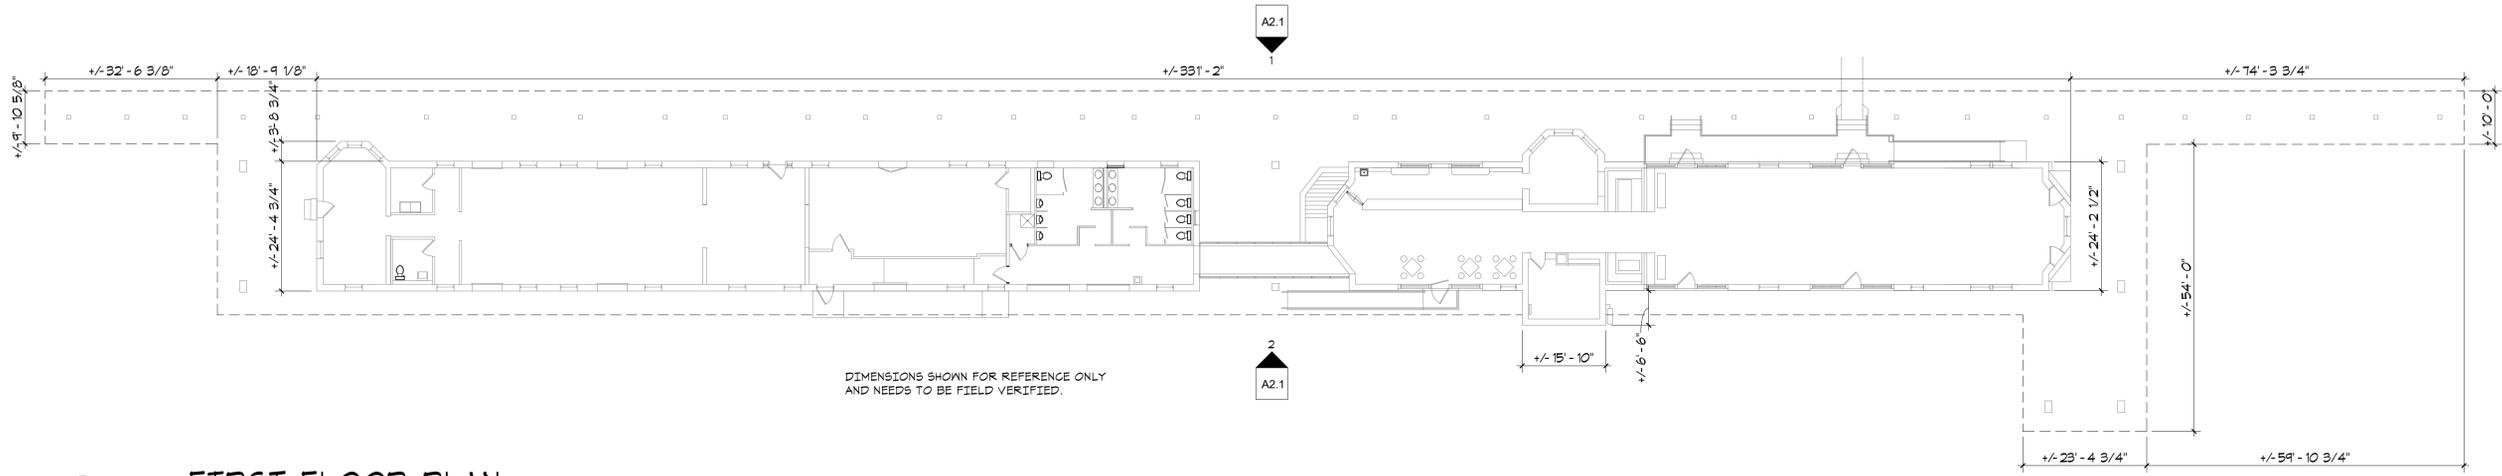

DIMENSIONS SHOWN FOR REFERENCE ONLY
AND NEEDS TO BE FIELD VERIFIED.

FIRST FLOOR PLAN
SCALE: 1/16" = 1'-0"

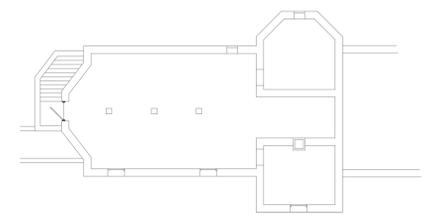


BASEMENT FLOOR PLAN
SCALE: 1/16" = 1'-0"

ASSEMBLIES - ROOF:

- ROOF ASSEMBLY 1** ASPHALT ROOF SHINGLES BY CERTAINTEED LANDMARK PRO (COLOR AS SELECTED BY OWNER FROM MFR STANDARD COLORS)
ROOF MEMBRANE
PROVIDE NEW FLASHINGS AND DRIP EDGE
REMOVE EXISTING ROOF AND ASSOCIATED FLASHINGS DOWN TO DECK
PROVIDE UNIT PRICE FOR DECK REPLACEMENT IF NEEDED
 - ROOF ASSEMBLY 2** COMPOSITE SLATE BY DAVINCI IV 8" EXPOSURE NON-STAGGERED PATTERN (COLOR AS SELECTED BY OWNER FROM MFR. STANDARD COLORS)
ROOF UNDERLAYMENT
PROVIDE NEW FLASHINGS AND DRIP EDGE
REMOVE EXISTING ROOF AND ASSOCIATED FLASHINGS DOWN TO DECK
PROVIDE UNIT PRICE FOR DECK REPLACEMENT IF NEEDED
- PROVIDE PROPER FLASHING AROUND ANY EXISTING ROOF PENETRATIONS PER MFR. REQUIREMENTS.



1 EAST ELEVATION
SCALE: 1/16" = 1'-0"

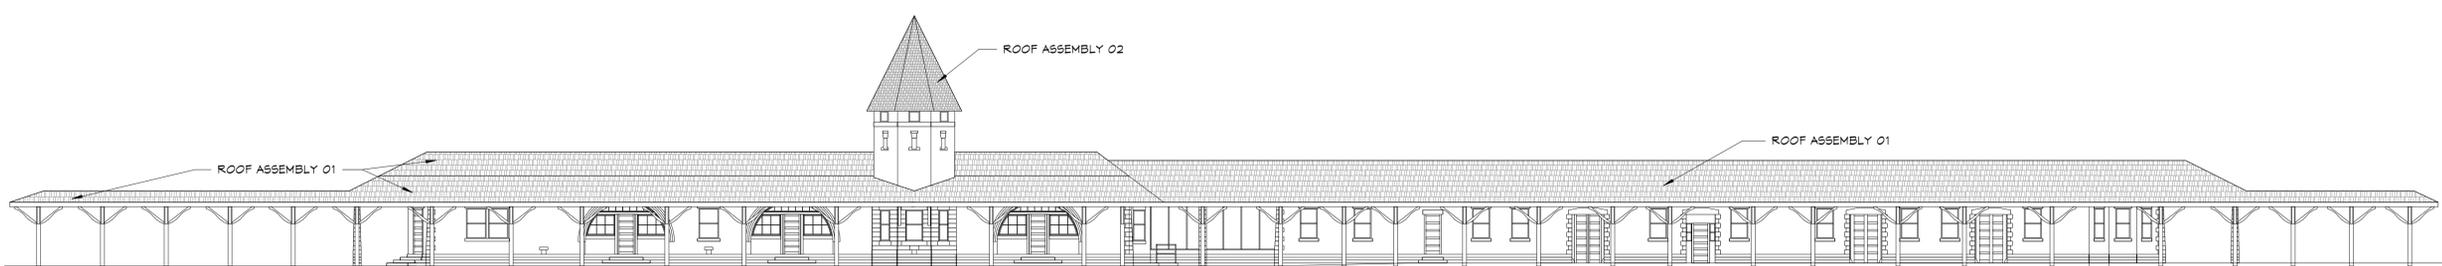

2 WEST ELEVATION
SCALE: 1/16" = 1'-0"